


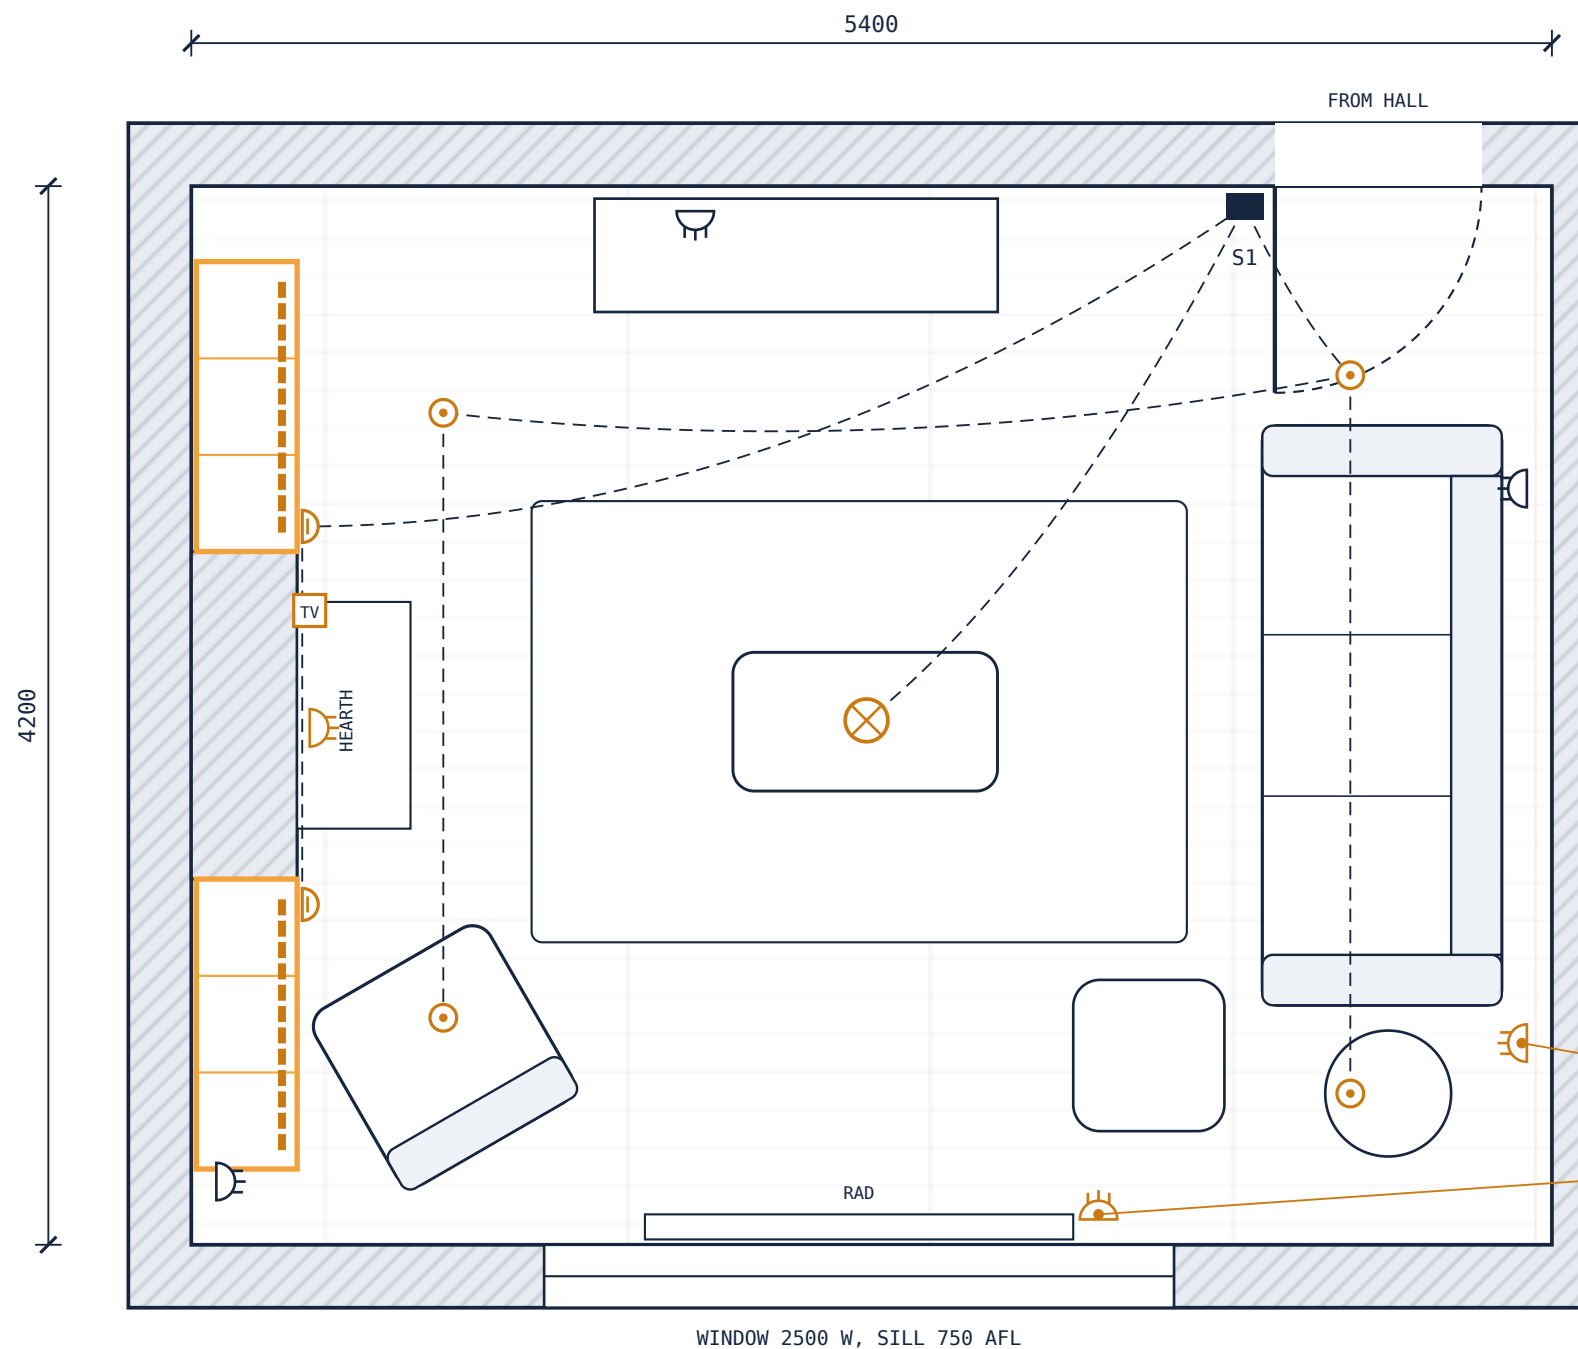

- LEGEND
- Pendant over coffee table, dimmable (S1-A)
 - LED downlight, warm white 2700K (S1-B)
 - Wall light, 1700 AFL (S1-C)
 - LED strip under alcove shelves (S1-C)
 - Double socket, existing
 - Double socket, new
 - S1: 3-gang dimmer plate, 1200 AFL
 - Switched together

NEW DOUBLE SOCKET FOR LAMP + CHARGING

NEW FLOOR-LEVEL SOCKET, 450 AFL

- NOTES
- All new electrical work by an electrician registered with a competent person scheme, who will certify it.
 - Replace existing 1-gang switch with a 3-gang dimmer plate (S1): A pendant, B downlights, C wall lights + shelf strips.
 - TV and data point plus a new double socket on the chimney breast at 1300 AFL, cables chased into the wall.
 - New sockets spur from the existing ring; electrician to confirm on site.
 - Downlights: check the ceiling void and joist direction before cutting.
 - AFL = above finished floor, to centre of fitting.
 - Kept sockets shown dark; new items shown in amber.

the
plan pal
theplanpal.co.uk · hello@theplanpal.co.uk

PROJECT
SAMPLE LIVING ROOM, 5.4 × 4.2M
Example drawing set. Not a real address.

DRAWING
Lighting & electrical plan

DRAWING NO.
ID-03

SCALE
1:30 @ A3

REV
A FIRST ISSUE OCT 2026